




Taco Bell

HANSON BLVD. & HWY. 10
COON RAPIDS, MN 55448


PRELIMINARY
NOT FOR
CONSTRUCTION

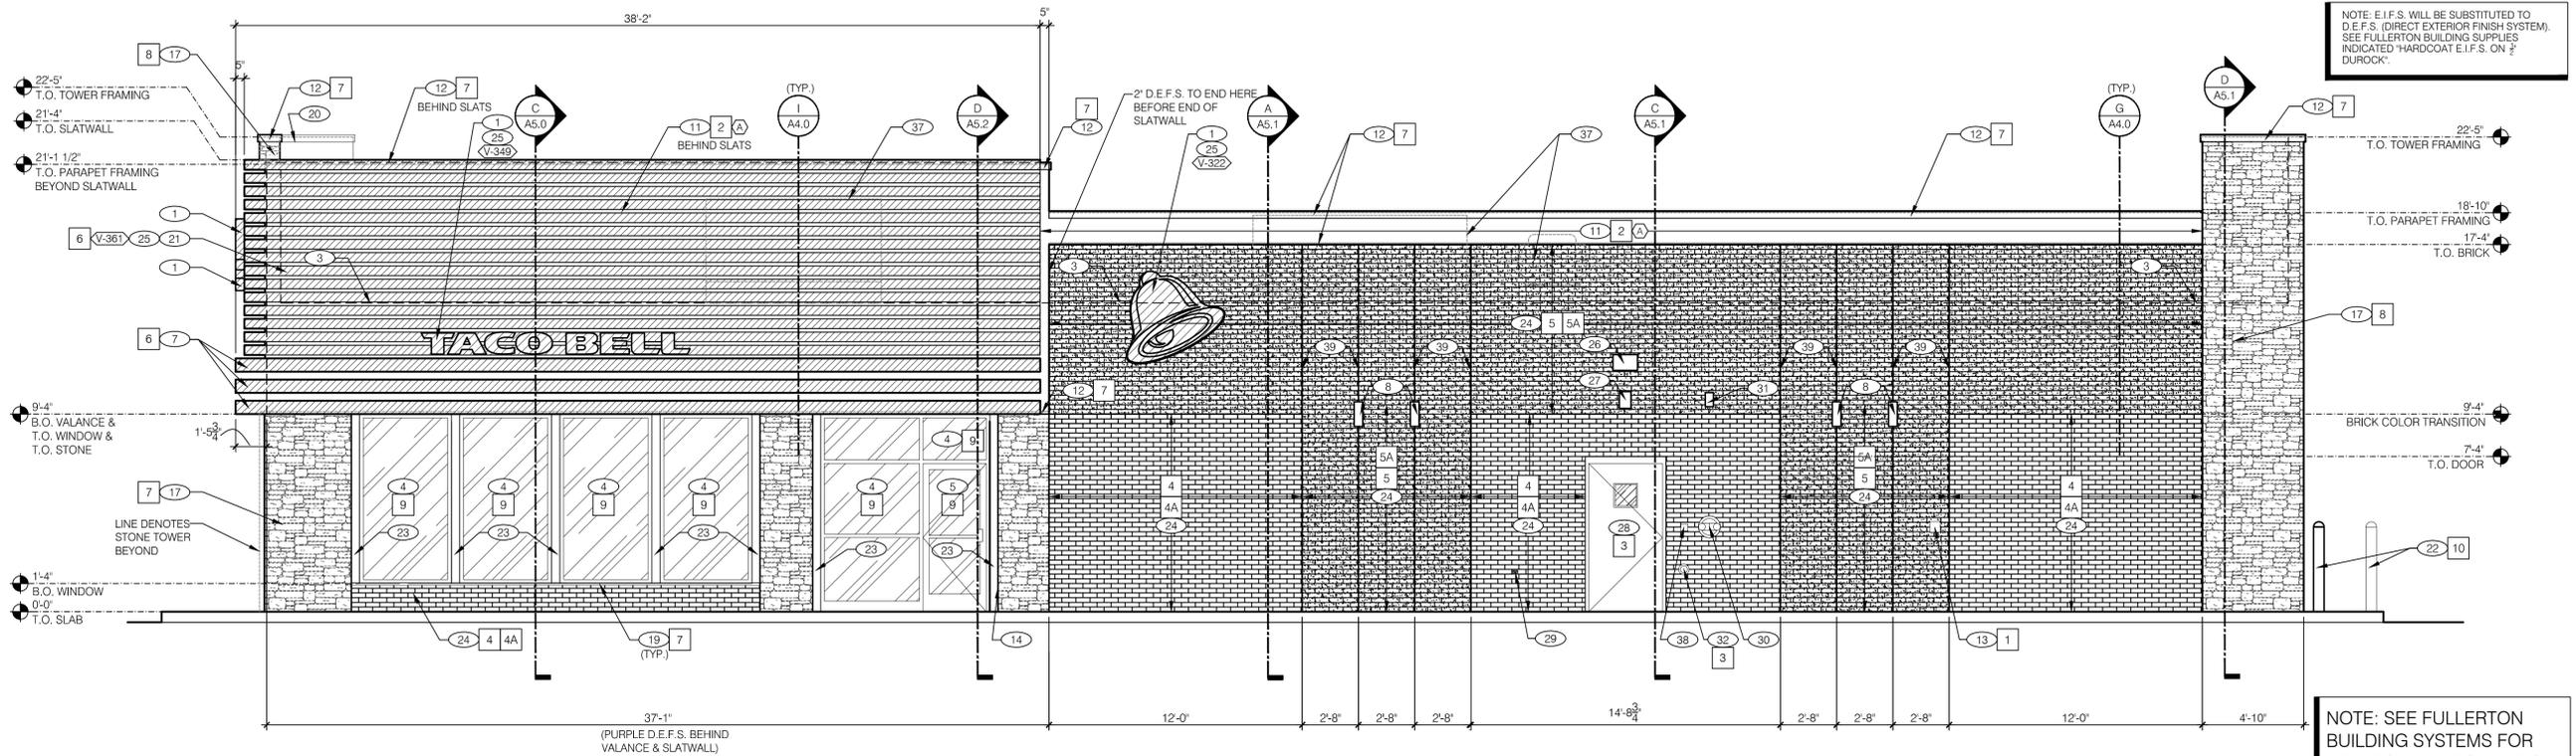


NOTE: E.I.F.S. WILL BE SUBSTITUTED TO D.E.F.S. (DIRECT EXTERIOR FINISH SYSTEM). SEE FULLERTON BUILDING SUPPLIES INDICATED "HARDCOAT E.I.F.S. ON 1/2\"/>

NOTE: SEE FULLERTON BUILDING SYSTEMS FOR ADDITIONAL INFORMATION.

EAST ELEVATION 1/4"=1'-0" **A**

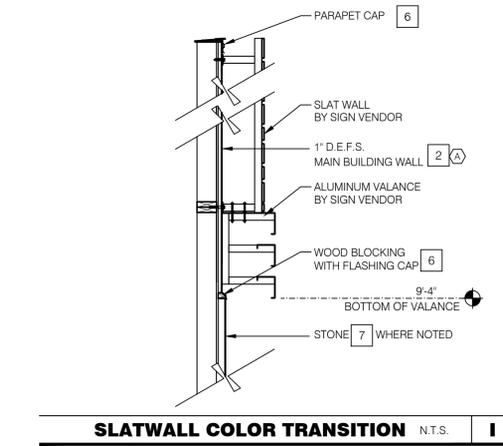

SLATWALL COLOR TRANSITION N.T.S. **I**

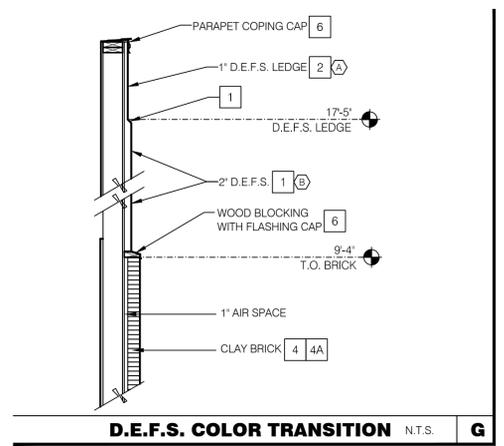

D.E.F.S. COLOR TRANSITION N.T.S. **G**

MISCELLANEOUS
A. SEE SHT A1.1 "WINDOW TYPES" FOR WINDOW ELEVATIONS.
B. NOT USED. "HIGH IMPACT" MESH SHALL BE USED WHERE NOTED.
C. THE PAINT COLORS SHOWN ARE COLOR REFERENCES FOR THE D.E.F.S. SUPPLIER (X/D).
D. D.E.F.S. TEXTURE SHALL BE "FINE".

SEALERS (REFER TO SPECS):
A. SEALANT AT ALL WALL AND ROOF PENETRATIONS.
B. SEALANT AT ALL WINDOW AND DOOR FRAMES AT HEAD AND JAMB. DO NOT SEAL SILL @ WINDOWS.
C. APPLY NEOPRENE GASKET (CONT.) BETWEEN BUILDING & CANOPY/TRELLIS.

LEGEND:
A. OWNERS SIGN VENDOR SCOPE INCLUDES: SUPPLY AND INSTALLATION OF ALUMINUM SLATWALL, VALANCE, CANOPIES, AND ALL SIGNAGE (SWINGING BELL AND LETTERS INCLUDED).
B. DENOTES CLAY BRICK: FULL MODULAR SIZE, 3 5/8" x 2 1/4" x 7 5/8"
B. DENOTES D.E.F.S. (DIRECT EXTERIOR FINISH SYSTEM)

***CRITICAL* DIMENSIONS:**
A. REQUIRED CLEAR OPENING WIDTH TO ENSURE COORDINATION WITH STANDARD SIGNAGE/BUILDING ELEMENTS DIMENSIONS.

GENERAL NOTES **F**

QTY	ITEM DESCRIPTION	ELEC
V-350 1	TACO BELL DRIVE THRU CANOPY	X
V-348 1	TACO BELL "BUILDING ACCENT"	X
V-361 3	SLAT WALL AND ALUMINUM VALANCE	X

* REQUIRES ELECTRICAL CONNECTION. SEE ELECTRICAL PLANS.

CANOPY AND BLDG. ACCENT SCHED. N.T.S. **E**

- BUILDING SIGN PROVIDED BY SIGN VENDOR. UNDER SEPARATE PERMIT.
- DRIVE THRU WINDOW. SEE SHEET A1.0 AND A1.1.
- DASHED LINES DENOTE ROOF PARAPET BEYOND.
- STOREFRONT WINDOW SYSTEM. TYPICAL.
- STOREFRONT DOOR
- SWITCH GEAR AND METER.
- ARCHITECTURAL ALUMINUM VALANCE PROVIDED BY SIGN VENDOR.
- LIGHT SCOURCE SUPPLIED BY OWNER. INSTALLED BY CONTRACTOR. COLOR DARK BRONZE. CENTERLINE OF ELECTRICAL BOX TO BE AT 9'-4" AFF.
- CANOPY WITH TURNBUCKELS PROVIDED BY SIGN VENDOR.
- PREFINISHED DARK BRONZE SCUPPER, COLLECTOR, AND OPEN FACE DOWNSPOUT.
- D.E.F.S. (TYP). SEE THICKNESS SCHEDULE B.
- PREFINISHED PARAPET COPING. IF DURO-LAST EDGE TRIM IS USED. USE THE DURO-LAST PRE-FINISHED EDGE TRIM.
- CO2 FILLER VALVE BOX & COVER. SEE DETAIL 5/A6.2 SIM.
- D.E.F.S. REVEAL JOINT.
- GAS SERVICE & METER. NO PAINT.
- WALL SHALL BE FINISHED PRIOR TO INSTALLATION OF SWITCHGEAR.
- SIMULATED STONE.
- ALUMINUM ROOF ACCESS LADDER AND DOOR. (DO NOT PAINT)
- PRE-FINISHED METAL CAP FLASHING. COLOR DARK BRONZE
- PARAPET SHOWN BEYOND.
- ALUMINUM SLAT WALL PROVIDED BY SIGN VENDOR.

(A) BASE THICKNESS - 1" THICK D.E.F.S.
(B) BASE THICKNESS - 2" THICK D.E.F.S.
D.E.F.S. = (DIRECT EXTERIOR FINISH SYSTEM)

D.E.F.S. THICKNESS N.T.S. **B**

QTY	ITEM DESCRIPTION	ELEC
V-349 2	TACO BELL LETTERS 12" HIGH, WHITE, FLAT FACED	X
V-322 2	TACO BELL "BELL" SIGN 4'-10" 1/2"W x 4'-6" 1/4"H	X

SIGN SCHEDULE N.T.S. **C**

- BOLLARD. INSTALL OWNER SUPPLIED PLASTIC COVERS.
- PREFINISHED BREAK METAL COVER OVER WOOD STUDS TO MATCH STOREFRONT COLOR DARK BRONZE. SEE 3.4 & 7/A6.1
- CLAY BRICK. SEE FINISH SCHEDULE H, THIS SHEET FOR MATERIALS & COLORS.
- PROVIDE 9/16" DIA. PAIGE WALL BUSTER PLASTIC CONDUIT STUBS INCLUDING NIPPLES THROUGH EXTERIOR WALL. INSTALL CONDUIT AT SLIGHT ANGLE DOWNWARDS TOWARD GRADE FOR EXTERIOR ILLUMINATED SIGNAGE AND SLAT WALL L.E.D. LIGHTING ONLY. COORDINATE LOCATIONS AND QUANTITIES OF CONDUIT WITH OWNERS SIGN MANUFACTURER/INSTALLER. SEAL ALL PENETRATIONS WEATHER TIGHT.
- WALL PACK LIGHT FIXTURE SUPPLIED BY OWNER, INSTALLED BY CONTRACTOR. COLOR DARK BRONZE.
- EMERGENCY LIGHT FIXTURE WITH BATTERY BACK-UP SUPPLIED BY OWNER INSTALLED BY CONTRACTOR. COLOR DARK BRONZE.
- EMERGENCY LIGHT / ALARM FOR FIRE SUPPRESSION SYSTEM.
- RELIEF VALVE PIPE FOR FIRE SUPPRESSION SYSTEM, PAINT.
- INSULATED METAL OVERHEAD SECTIONAL DOOR, PAINT.
- KEY PAD OPENER FOR OVERHEAD SECTIONAL DOOR.
- STEEL PLATE JAMBS AND HEAD AT OVERHEAD SECTIONAL DOOR. PRIME AND EPOXY PAINT TO MATCH DARK BRONZE COLOR AT STOREFRONT.
- FRESH AIR INTAKE METAL GRILLE. SEAL AND PAINT.
- DASHED LINES DENOTE ROOF TOP EQUIPMENT BEHIND PARAPET.
- PROVIDE FIRE DEPARTMENT KNOX BOX, VERIFY LOCATION WITH FIRE MARSHALL.
- 1/2" CONTROL JOINT WITH BACKER ROD AND SEALANT.

KEY NOTES **D**

SYMBOL	AREA	MANUFACTURER	COLOR
1	MAIN BUILDING COLOR (D.E.F.S.)	SHERWIN WILLIAMS	SW 6122 "CAMEL BACK"
2	WALL BEHIND SLATWALL/PARAPET (D.E.F.S.)	SHERWIN WILLIAMS	SW 6831 "CLEMATIS"
3	PAINT	SHERWIN WILLIAMS	SW 2823 "ROCKWOOD CLAY"
4	CLAY BRICK	ACME BRICK	(101) CINNAMON BROWN OR APPROVED EQUAL CLAY BRICK
4A	BRICK MORTAR	ACME BRICK	MORTAR TO MATCH BRICK COLOR (101) CINNAMON BROWN
5	CLAY BRICK	ACME BRICK	(105) GOLDEN SUNSET OR APPROVED EQUAL CLAY BRICK
5A	BRICK MORTAR	ACME BRICK	MORTAR TO MATCH BRICK COLOR (105) GOLDEN SUNSET
6	SLATWALL, VALANCE AND CANOPY COLOR	SHERWIN WILLIAMS	SW 7034 "STATUS BRONZE"
7	PARAPET ROOF COPING & FLASHING	-	PREFINISHED: DARK BRONZE
8	SIMULATED STONE	BORAL STONE PRODUCTS	PROSTONE LEDGESTONE "VINTAGE WINE" PRO-482284
9	STOREFRONT WINDOWS & DOOR	TBD	PREFINISHED: ALUMINUM ANODIZED. COLOR: "DARK BRONZE"
10	PIPE BOLLARDS	STREET SMART	YELLOW - 1/4" THICK PLASTIC COVER (US.POSTMAN.COM) OR EQUAL

EXTERIOR FINISH SCHEDULE **H**

EXTERIOR FINISH
1. CONTACT FOR EXTERIOR FINISH #6 AND #7 IS:
VERSETTA STONE WALL
GENE GUETZOW
262-215-6373

2. OWNERS REPRESENTATIVE WILL IDENTIFY IF LOTUSAN PAINT WILL BE USED.

Border Foods
5425 Boone Ave N.
New Hope, MN 55428

I hereby certify that this plan was prepared by me or under my direct supervision and that I am a duly licensed architect under the laws of the State of Minnesota.

Signature:
Name: Dave Clark
Registration: 14,883
Project Contact: Dean Madison
Phone Number: 952.541.9969

Print History
CITY PLANNING REVIEW 01-12-2015
CITY PLANNING REVIEW 02-03-2015
-
-
-
-
-
-

New Building
T-50, 64 Seats: 2,831 SF

EXTERIOR ELEVATIONS

Project: 2014.0602
Drawn: JDS
Checked: DSM

A4.0

TACO BELL COON RAPIDS, MN.